

**TOWN OF BLIND RIVER
REQUEST FOR TENDER
NEW BLIND RIVER WATER TREATMENT PLANT INTAKE AND LOW LIFT PUMPING STATION
CONTRACT NO. PS-2026-01**

**ADDENDUM #13
March 19th, 2026**

This addendum shall form part of the Contract Documents. The Addendum issued shall be indicated in FT.05 ADDENDA of the FORM OF TENDER.

ADDITIONS & DELETIONS TO THE TENDER

Please find enclosed the sketches referenced in Addendum #12.

End of Addendum 13

Encls.

Conduit Detail (1 page)


Pipe Path (2 pages)


Carrier Pipe
5" DR32.5, IPS HDPE

Sampling Pipe
1" DR11, IPS HDPE

Sodium Hypochlorite Pipe
3/4" DR11, IPS HDPE

Compressed Air Pipe
3" DR11, IPS HDPE

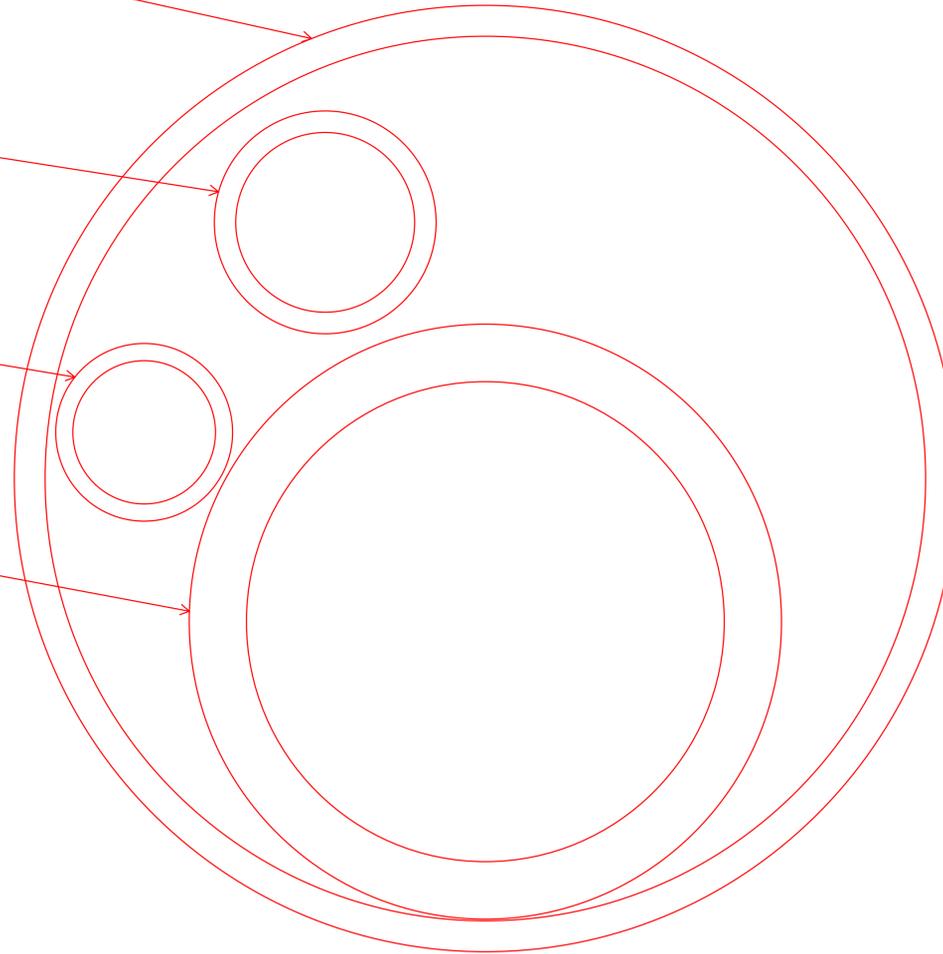

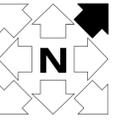

KEY PLAN



ENGINEER'S SEAL:



JAN 2026	0	ISSUED FOR TENDER	NP	TK
DATE	REV.	REVISION	BY	APPD.

CLIENT:



CONSULTANT:



CONSULTANT:




PROJECT TITLE:

NEW BLIND RIVER WTP INTAKE AND LLPS


DRAWING TITLE:

LLPS GROUND FLOOR

NP	EDA	CARS	TK
DRAWN	DESIGNED	CHECKED	APPROVED
1 : 50		JAN 2026	
SCALE		DATE	
T001592B	0	D-101	
PROJECT NO.	REVISION	DRAWING	

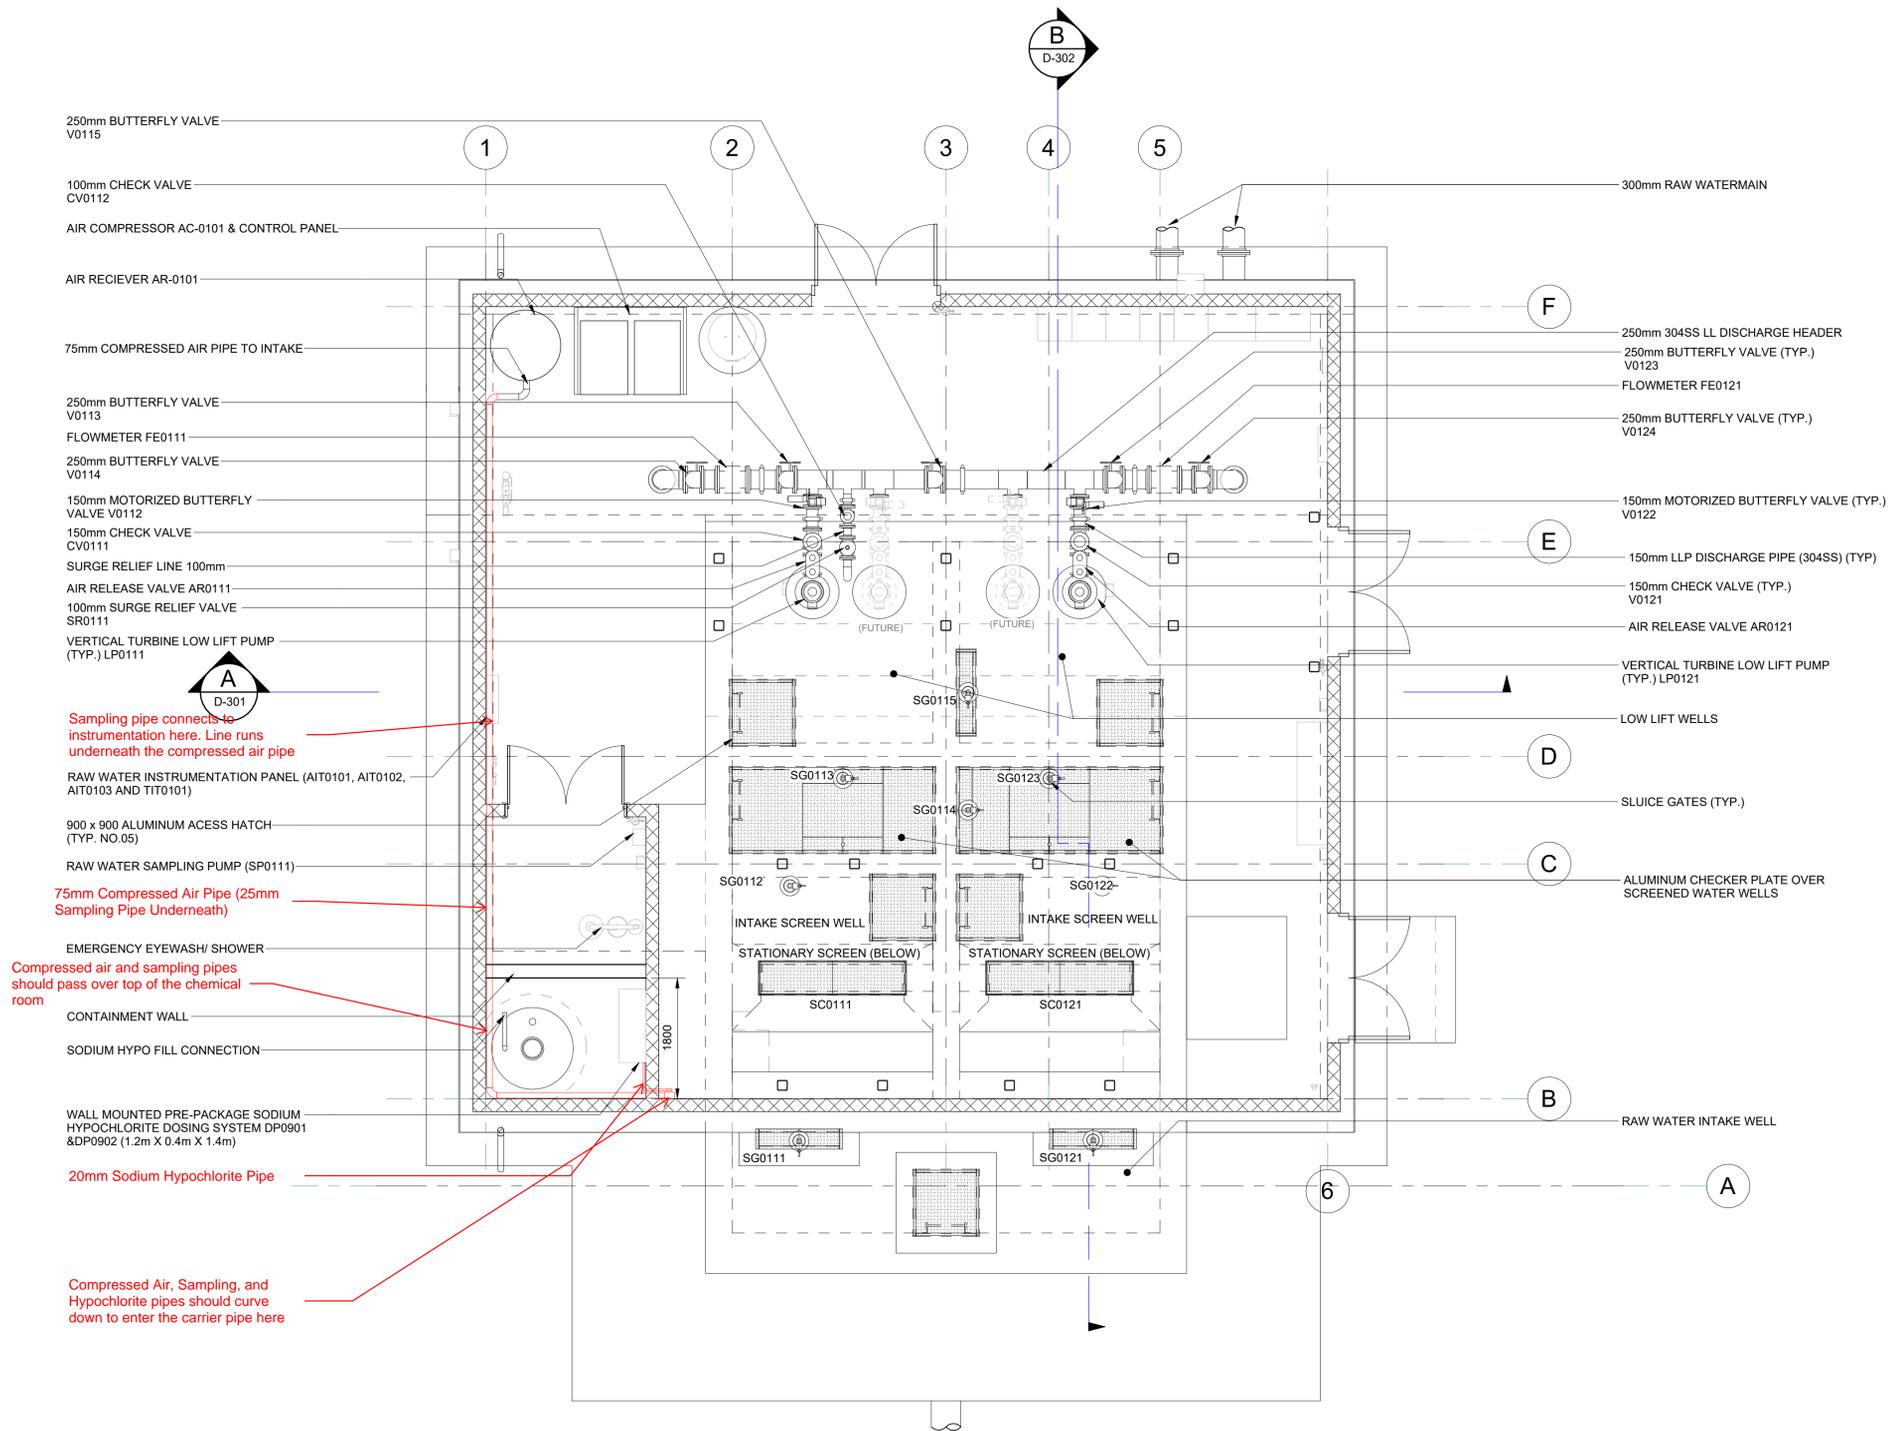

1 GROUND FLOOR PLAN
D-301 SCALE: 1 : 50

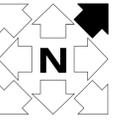

KEY PLAN



ENGINEER'S SEAL:



DATE	REV.	REVISION	BY	APPD.
JAN 2026	0	ISSUED FOR TENDER	NP	TK

CLIENT:



CONSULTANT:



CONSULTANT:



PROJECT TITLE:

NEW BLIND RIVER
WTP INTAKE AND
LLPS

DRAWING TITLE:

LLPS LOWER
LEVEL

NP	EDA	C/RS	TK
DRAWN	DESIGNED	CHECKED	APPROVED
1 : 50		JAN 2026	
SCALE		DATE	
T001592B	0	D-102	
PROJECT NO.	REVISION	DRAWING	

